
 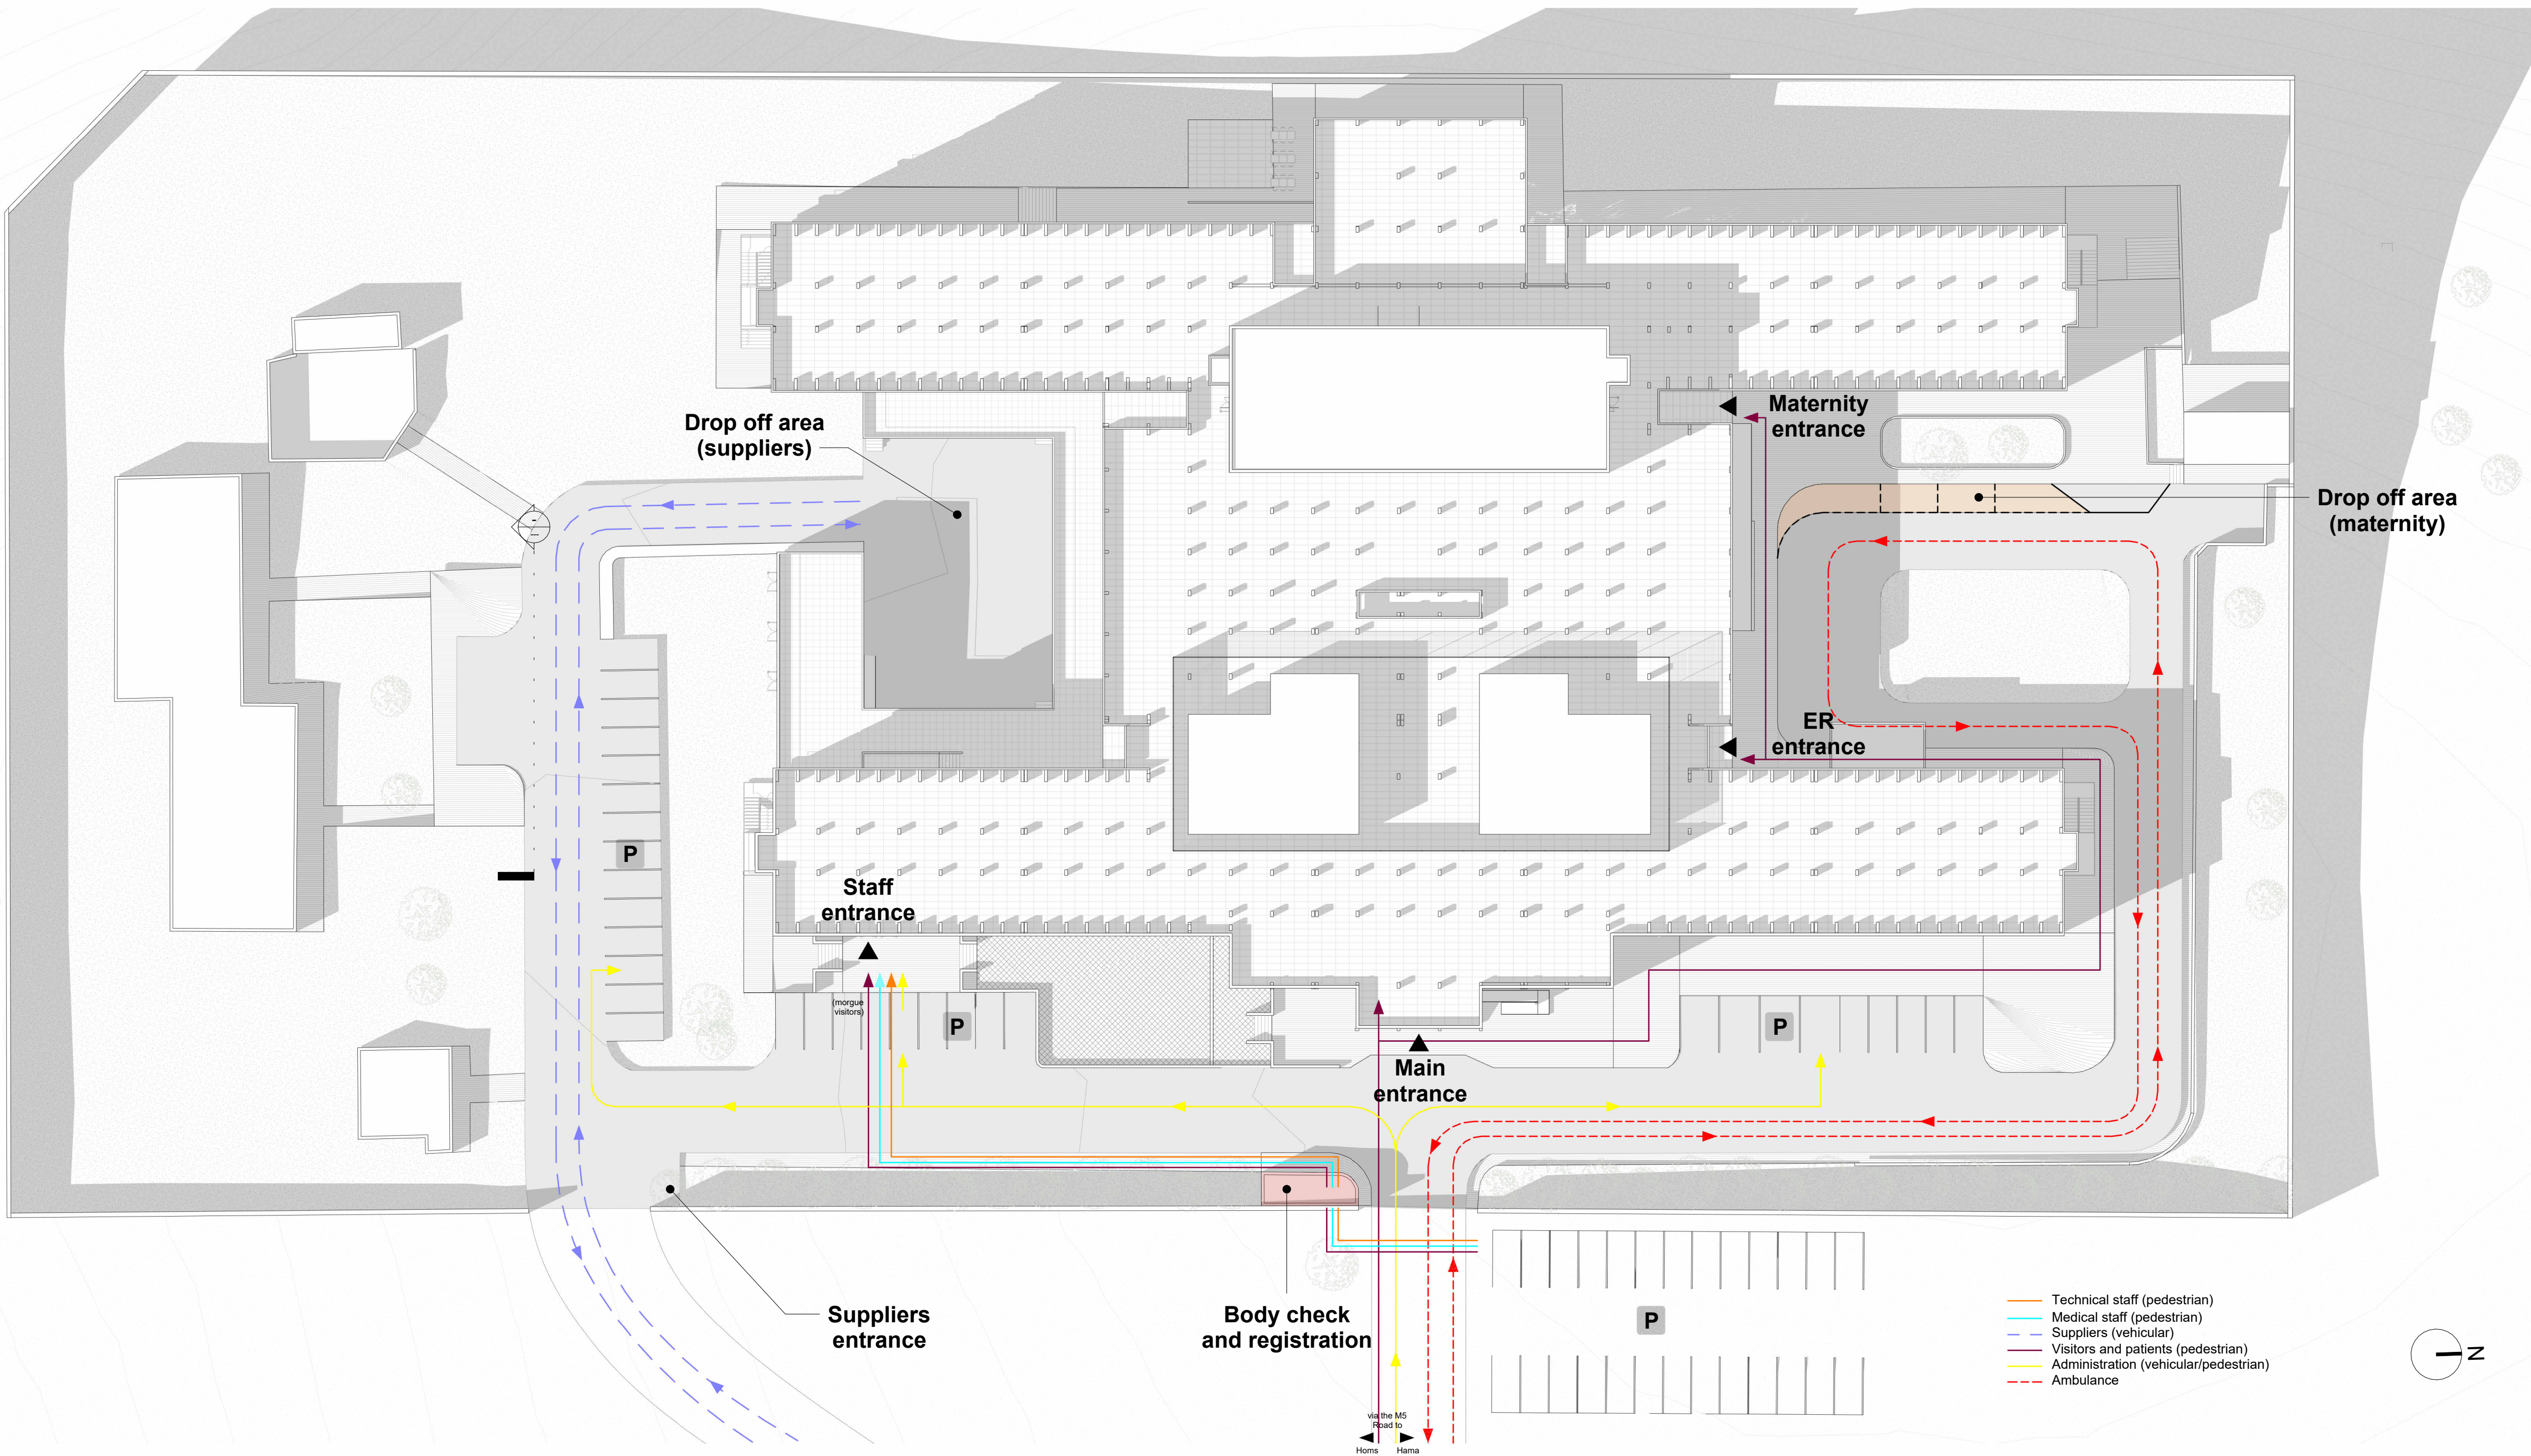



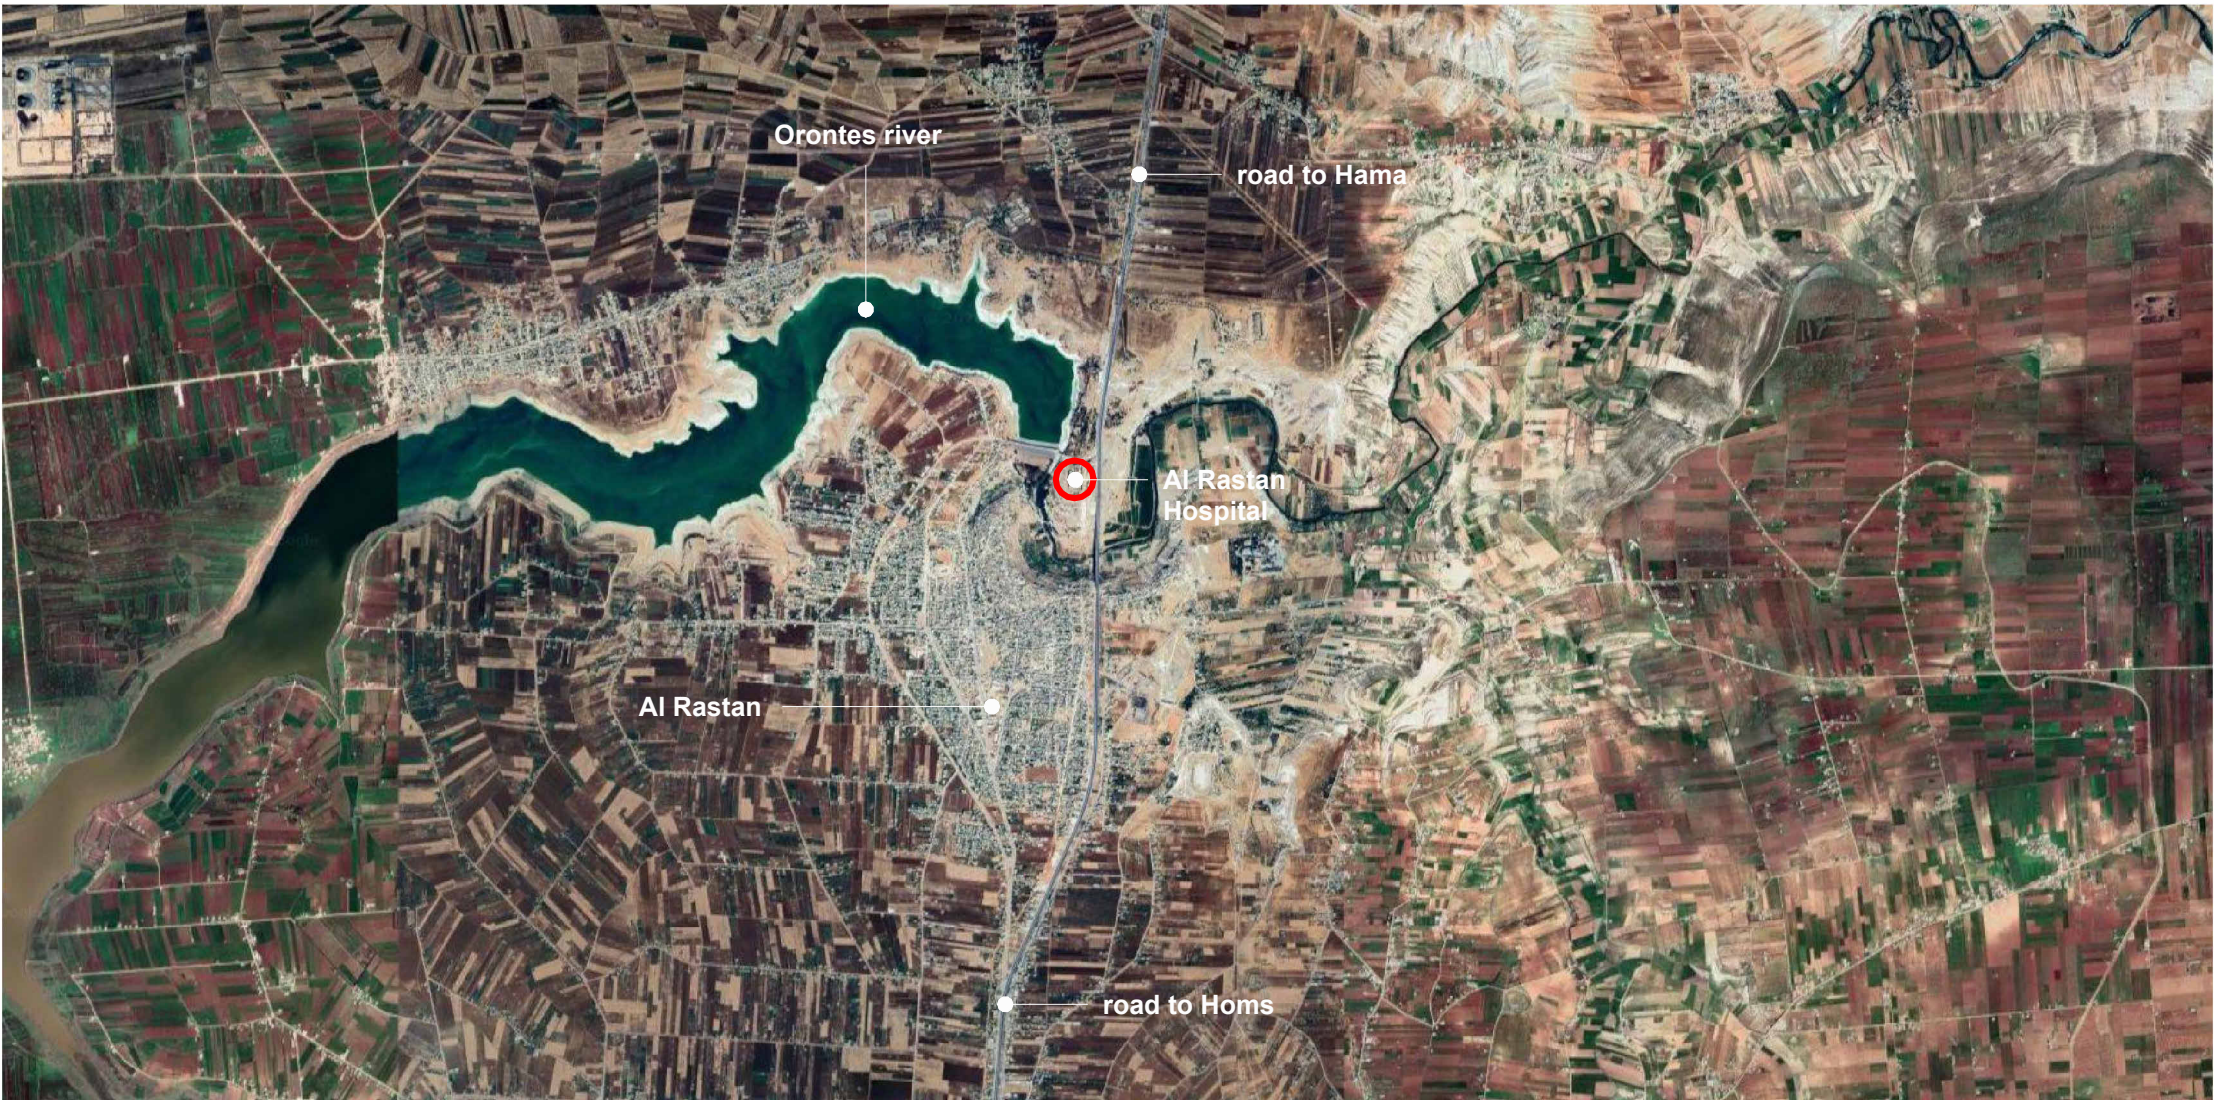

Site Plan
1 : 350

Key plan

Notes:

1. This drawing is a copyright © of TAMassociati
2. Do not scale off this drawing
3. All levels and dimensions to be checked on site before any building work commences
4. Any discrepancies to be reported to the office of the consultant
5. All work to be strictly in accordance with the standard specifications and notes
6. This drawing is to be read in conjunction with specifications and all other relevant drawings
7. All dimensions are in meters unless differently specified in the drawings

Municipality
**AL RASTAN
(SY)**

Client:

EMERGENCY ONG ETS
via S. Croce, 19
Milan (Italy)

Site address:

M5 road
Al Rastan (Syria)

ARH

**AL RASTAN HOSPITAL
Renovation**

Architectural project



TAMassociati
Dorsoduro 2731 | 30123 Venice (Italy)
+39 3453141287 | info@tamassociati.org



EMERGENCY building division
via S. Croce, 19 | 20122 Milan (Italy)
+39 02981181 | info@emergency.it

Design Team

Local medical planner:



Innotech Medical
Eng. Bahaa Al Satri
Office #303, Al Rayhan | Building Al Manzar, Dubai, UAE
+971 508726966
Toll-free: near the Italian Hospital | Damascus, Syria
+963 958259880 | +963 116440355 | b.alsatri@innotech-med.com

MEP engineering:



Rethink Energy
via Francesco Melzi d'Eril, 26 | 20154 Milano (Italy)
+39 0245558665 | info@studio-re.eu

**Preliminary project
Site Plan**

Date:	Scale:				
03/07/26	1 : 350				
Rev.	Date	DRW	CHK	APR	Description

Drawing number:

ARH-A.000

Rooms Specifications

- the Doctors' rooms include resting and meeting area
- the C.U.R. rooms (Clean Utility Room) include 4 sqm. of linen storage space
- the D.U.R. rooms (Dirty Utility Room) include 1 sluice
- the Nursing stations room include 1 sink, storage space, 1 dressing trolley, 1 emergency cart

Plan - Basement
1 : 200

Basement A - Laundry

Name	Number Area
Store	-1.A.01 50.72 m²
D.U.R.	-1.A.02 7.99 m²
WC public	-1.A.03 4.19 m²
C.H.	-1.A.04 12.37 m²
WC public	-1.A.05 4.85 m²
C.H.	-1.A.06 13.28 m²
Laundry entrance	-1.A.07 52.32 m²
Washing Area	-1.A.08 69.47 m²
Dry area	-1.A.09 63.85 m²
Tailoring	-1.A.10 49.53 m²

Basement B - Technical area

Name	Number Area
Technical Area	-1.B.01 262.70 m²
D.U.R.	-1.B.02 20.38 m²
IT CED	-1.B.03 18.69 m²
UPS	-1.B.04 25.54 m²
Fire lighting	-1.B.05 12.41 m²
C.H.	-1.B.06 19.01 m²
Main Switch board Room	-1.B.07 40.96 m²
Phon	-1.B.08 61.85 m²
Technical Workshop	-1.B.09 29.92 m²
Technical Store	-1.B.10 32.66 m²

Basement C - Changing room

Name	Number Area
WC	-1.C.01 25.29 m²
CH medical staff	-1.C.02 50.07 m²
CH (female)	-1.C.03 32.09 m²
CH (male)	-1.C.04 39.97 m²
WC	-1.C.05 7.09 m²
CH technical staff	-1.C.06 36.86 m²
CH (female)	-1.C.07 6.83 m²
CH technical staff	-1.C.08 36.44 m²
CH (male)	-1.C.09 22.03 m²
Distribution room	-1.C.10 24.44 m²
Parking point	-1.C.11 5.49 m²
Corridor	-1.C.12 8.87 m²
WC	-1.C.13 23.45 m²
CH medical staff	-1.C.14 54.34 m²
CH (female)	-1.C.15 23.11 m²
WC	-1.C.16 45.52 m²
CH (male)	-1.C.17 13.33 m²
CH (female)	-1.C.18 13.33 m²
CH (male)	-1.C.19 13.33 m²
CH (female)	-1.C.20 13.33 m²
CH (male)	-1.C.21 13.33 m²
CH (female)	-1.C.22 13.33 m²
CH (male)	-1.C.23 13.33 m²
CH (female)	-1.C.24 13.33 m²
CH (male)	-1.C.25 13.33 m²
CH (female)	-1.C.26 13.33 m²
CH (male)	-1.C.27 13.33 m²
CH (female)	-1.C.28 13.33 m²
CH (male)	-1.C.29 13.33 m²
CH (female)	-1.C.30 13.33 m²
CH (male)	-1.C.31 13.33 m²
CH (female)	-1.C.32 13.33 m²
CH (male)	-1.C.33 13.33 m²
CH (female)	-1.C.34 13.33 m²
CH (male)	-1.C.35 13.33 m²
CH (female)	-1.C.36 13.33 m²
CH (male)	-1.C.37 13.33 m²
CH (female)	-1.C.38 13.33 m²
CH (male)	-1.C.39 13.33 m²
CH (female)	-1.C.40 13.33 m²
CH (male)	-1.C.41 13.33 m²
CH (female)	-1.C.42 13.33 m²
CH (male)	-1.C.43 13.33 m²
CH (female)	-1.C.44 13.33 m²
CH (male)	-1.C.45 13.33 m²
CH (female)	-1.C.46 13.33 m²
CH (male)	-1.C.47 13.33 m²
CH (female)	-1.C.48 13.33 m²
CH (male)	-1.C.49 13.33 m²
CH (female)	-1.C.50 13.33 m²
CH (male)	-1.C.51 13.33 m²
CH (female)	-1.C.52 13.33 m²
CH (male)	-1.C.53 13.33 m²
CH (female)	-1.C.54 13.33 m²
CH (male)	-1.C.55 13.33 m²
CH (female)	-1.C.56 13.33 m²
CH (male)	-1.C.57 13.33 m²
CH (female)	-1.C.58 13.33 m²
CH (male)	-1.C.59 13.33 m²
CH (female)	-1.C.60 13.33 m²
CH (male)	-1.C.61 13.33 m²
CH (female)	-1.C.62 13.33 m²
CH (male)	-1.C.63 13.33 m²
CH (female)	-1.C.64 13.33 m²
CH (male)	-1.C.65 13.33 m²
CH (female)	-1.C.66 13.33 m²
CH (male)	-1.C.67 13.33 m²
CH (female)	-1.C.68 13.33 m²
CH (male)	-1.C.69 13.33 m²
CH (female)	-1.C.70 13.33 m²
CH (male)	-1.C.71 13.33 m²
CH (female)	-1.C.72 13.33 m²
CH (male)	-1.C.73 13.33 m²
CH (female)	-1.C.74 13.33 m²
CH (male)	-1.C.75 13.33 m²
CH (female)	-1.C.76 13.33 m²
CH (male)	-1.C.77 13.33 m²
CH (female)	-1.C.78 13.33 m²
CH (male)	-1.C.79 13.33 m²
CH (female)	-1.C.80 13.33 m²
CH (male)	-1.C.81 13.33 m²
CH (female)	-1.C.82 13.33 m²
CH (male)	-1.C.83 13.33 m²
CH (female)	-1.C.84 13.33 m²
CH (male)	-1.C.85 13.33 m²
CH (female)	-1.C.86 13.33 m²
CH (male)	-1.C.87 13.33 m²
CH (female)	-1.C.88 13.33 m²
CH (male)	-1.C.89 13.33 m²
CH (female)	-1.C.90 13.33 m²
CH (male)	-1.C.91 13.33 m²
CH (female)	-1.C.92 13.33 m²
CH (male)	-1.C.93 13.33 m²
CH (female)	-1.C.94 13.33 m²
CH (male)	-1.C.95 13.33 m²
CH (female)	-1.C.96 13.33 m²
CH (male)	-1.C.97 13.33 m²
CH (female)	-1.C.98 13.33 m²
CH (male)	-1.C.99 13.33 m²
CH (female)	-1.C.100 13.33 m²

Basement D - Administration

Name	Number Area
Office IT	-1.D.01 28.44 m²
IT area	-1.D.02 9.05 m²
WC staff	-1.D.03 5.08 m²
WC public	-1.D.04 4.44 m²
Meeting room	-1.D.05 15.22 m²
Facility manager office	-1.D.06 15.17 m²
Lighttech office	-1.D.07 58.20 m²
D.U.R.	-1.D.08 6.14 m²

Basement E - High frequency store

Name	Number Area
Store	-1.E.01 160.75 m²
Store	-1.E.02 84.77 m²
Office	-1.E.03 13.33 m²
WC staff	-1.E.04 5.08 m²
WC public	-1.E.05 4.44 m²
Parking point	-1.E.06 46.34 m²
Biomedical Store	-1.E.07 58.87 m²

Basement F - Sterilization

Name	Number Area
Office	-1.F.01 13.33 m²
Body washing Room	-1.F.02 13.33 m²
Family washing Area	-1.F.03 13.33 m²
Waiting Area	-1.F.04 13.33 m²
WC public	-1.F.05 4.44 m²
WC staff	-1.F.06 5.08 m²
Rest	-1.F.07 13.33 m²
Cool store	-1.F.08 18.13 m²
Corridor	-1.F.09 6.50 m²

Basement G - Morgue

Name	Number Area
Office	-1.G.01 13.33 m²
Body washing Room	-1.G.02 13.33 m²
Family washing Area	-1.G.03 13.33 m²
Waiting Area	-1.G.04 13.33 m²
WC public	-1.G.05 4.44 m²
WC staff	-1.G.06 5.08 m²
Rest	-1.G.07 13.33 m²
Cool store	-1.G.08 18.13 m²
Corridor	-1.G.09 6.50 m²

Basement H - Pharmacy store

Name	Number Area
Pharmacy Store	-1.H.01 160.75 m²
General Store	-1.H.02 84.77 m²
CH	-1.H.03 13.33 m²
WC staff	-1.H.04 5.08 m²
WC public	-1.H.05 4.44 m²
Locate	-1.H.06 4.03 m²
Temperature controlled	-1.H.07 27.15 m²
Shop	-1.H.08 28.01 m²
Office	-1.H.09 42.16 m²
Dispensary	-1.H.10 15.09 m²
Corridor	-1.H.11 94.32 m²

Basement I - Biomedical

Name	Number Area
Locate	-1.I.01 160.75 m²
Locate	-1.I.02 84.77 m²
Office	-1.I.03 13.33 m²
WC staff	-1.I.04 5.08 m²
WC public	-1.I.05 4.44 m²
Locate	-1.I.06 4.03 m²
Temperature controlled	-1.I.07 27.15 m²
Shop	-1.I.08 28.01 m²
Office	-1.I.09 42.16 m²
Dispensary	-1.I.10 15.09 m²
Corridor	-1.I.11 94.32 m²

Basement J - Canteen

Name	Number Area
WC staff	-1.J.01 7.97 m²
WC staff	-1.J.02 7.43 m²
Canteen	-1.J.03 203.37 m²

Basement K - Kitchen

Name	Number Area
Store	-1.K.01 13.01 m²
Store	-1.K.02 38.10 m²
Food Preparation	-1.K.03 123.74 m²
Waste management	-1.K.04 15.84 m²
Fridges	-1.K.05 7.09 m²
Food Store	-1.K.06 31.09 m²
Food Reception	-1.K.07 76.10 m²
Food Reception	-1.K.08 36.02 m²
CH	-1.K.09 11.86 m²
WC staff	-1.K.10 3.57 m²
WC staff	-1.K.11 3.57 m²
CH	-1.K.12 11.86 m²
D.U.R.	-1.K.13 4.11 m²
Corridor	-1.K.14 22.19 m²

Basement L - General store

Name	Number Area
Materials reception	-1.L.01 140.05 m²
Office	-1.L.02 20.03 m²
WC staff	-1.L.03 5.31 m²
WC staff	-1.L.04 5.32 m²
Low Frequency Store	-1.L.05 140.69 m²
Corridor	-1.L.06 30.71 m²

Basement M - Corridor and Services

Name	Number Area
Corridor	-1.M.01 533.91 m²
Water Room	-1.M.02 14.94 m²
D.U.R.	-1.M.03 4.24 m²
Waste management	-1.M.04 24.09 m²
D.U.R.	-1.M.05 6.26 m²

Room schedules

Key plan

Notes:

- This drawing is a copyright © of TAMassociati
- Do not scale off this drawing
- All levels and dimensions to be checked on site before any building work commences
- Any discrepancies to be reported to the office of the consultant
- All work to be strictly in accordance with the standard specifications and notes
- This drawing is to be read in conjunction with specifications and all other relevant drawings
- All dimensions are in meters unless differently specified in the drawings

Municipality
AL RASTAN (SY)

Client:

EMERGENCY ONG ETS
via S. Croce, 19
Milan (Italy)

Site address:

M5 road
Al Rastan (Syria)

ARH

**AL RASTAN HOSPITAL
Renovation**

Architectural project



TAMassociati

Dorsoduro 2731 | 30123 Venice (Italy)
+39 0415075985 | info@tamassociati.org



EMERGENCY building division

via S. Croce, 19 | 20122 Milano (Italy)
+39 02281181 | info@emergency.it

Design Team

Local medical planner:



Innotech Medical

Eng Bahaa Al Satri
Office #303, Al Rayhan | Building Al Manzar, Dubai, UAE
+971 508726985
Tallery, near the Italian Hospital | Damascus, Syria
+963 958250880 | +963 115440355 | b.alsatri@innotech-medi.com

MEP engineering:



Rethink Energy

via Francesco Mezi d'Eril, 26 | 20154 Milano (Italy)
+39 0245558665 | info@rethink-energy.eu

**Preliminary project
Basement - Project**

Date:

03/07/26

Scale:

1 : 200

Rev. Date DRW CHK APR Description

Drawing number:

ARH-A.001

- the Doctors' rooms include resting and meeting area
- the C.U.R. rooms (Clean Utility Room) include 4 sqm. of linen storage space
- the D.U.R. rooms (Dirty Utility Room) include 1 sluice
- the Nursing stations room include 1 sink, storage space, 1 dressing trolley, 1 emergency cart



- Notes:**
1. This drawing is a copyright © of TAMassociati
 2. Do not scale off this drawing
 3. All levels and dimensions to be checked on site before any building work commences
 4. Any discrepancies to be reported to the office of the consultant
 5. All work to be strictly in accordance with the standard specifications and notes
 6. This drawing is to be read in conjunction with specifications and all other relevant drawings
 7. All dimensions are in meters unless differently specified in the drawings

EMERGENCY ONG ETS
via S. Croce, 19
Milan (Italy)

M5 road
stan (Syria)



TAMassociati

EMERGENCY building division
via S. Croce, 19 | 20122 Milan (Italy)
+39 02881881 | info@emergency.it

Local medical

Innotech Medical

Eng. Bahaa Al Sairafi
Rayhan | Building Al Mamzar, Dubai, UAE
+971 506726988
near the Italian Hospital | Damascus, Syria
16440305 | b.alsairafi@innotech-med.com

 Rethink Energy

Rethink Energy
36 | 30154 Milano (Italy)

+39 0245558885 | info@studio-re.eu

Preliminary project

Ground Floor - Project

Date:	Scale:
-------	--------

Rev. Date DRW CHK APR Des

Drawing number:
ARH-A.002

Plan - Ground Floor
1 : 200

Ground Floor A - ER Department		
	Number Area	
PDF (green)	0.81	17.56 m ²
Procedure room (green)	0.81	18.68 m ²
Exam room (green)	0.83	15.30 m ²
Examination room (green)	0.81	15.68 m ²
Medical store	0.85	2.95 m ²
Locale	0.96	2.55 m ²
Waiting area (green)	0.87	35.61 m ²
Public	0.86	2.47 m ²
WC public	0.89	3.61 m ²
Waiting area (yellow)	0.10	54.88 m ²
Reception	0.12	2.72 m ²
Shock room	0.12	51.64 m ²
Stretch	0.13	10.34 m ²
D.U.R.	0.14	4.89 m ²
Nursing station/Medical store	0.15	1.57 m ²
C.U.R.	0.16	7.61 m ²
WC staff	0.17	2.81 m ²
WC staff	0.18	2.91 m ²
Rest	0.19	11.87 m ²
Exam room (yellow)	0.20	11.87 m ²
Exam room (yellow)	0.21	12.16 m ²
Exam room (yellow)	0.22	16.11 m ²

**Ground Floor A - ER
Department**

Name	Number A
Observation (male)	0.2.23
Locale	0.2.24
Observation (female)	0.2.25
D.U.R.	0.2.26
Paediatric exam, room	0.2.27
Paediatric exam, room	0.2.28
Paediatric observation	0.2.29
WC	0.2.30
Corridor	0.2.31
Corridor	0.2.32
Corridor	0.2.33
Corridor	0.2.34
Corridor	0.2.35
Store	0.2.36

Ground Floor B - Entrance and Reception

Name	Number	Area
WC public	0.8.01	8.34 m ²
WC public	0.8.02	8.34 m ²
Outpatient pharmacy	0.8.03	17.82 m ²
Outpatient pharmacy store	0.8.04	30.04 m ²
WC public	0.8.05	9.12 m ²

Ground Floor C - OPD

Name	Number	Area
WC public	0.C.01	4.00 m ²
WC public	0.C.02	4.00 m ²
WC staff	0.C.03	3.55 m ²
WC staff	0.C.04	3.54 m ²
Doctors' room/Rest	0.C.05	16.12 m ²
Paediatric	0.C.06	16.93 m ²
Paediatric	0.C.07	15.50 m ²
Dressing	0.C.08	16.86 m ²
Trauma	0.C.09	16.34 m ²
Trauma	0.C.10	16.35 m ²
Paediatric	0.C.11	16.56 m ²
POP	0.C.12	16.52 m ²
D.U.R.	0.C.13	5.69 m ²
C.U.R.	0.C.14	5.66 m ²
Nursing station	0.C.15	12.45 m ²
Waiting area	0.C.16	29.28 m ²
Waiting area	0.C.17	33.11 m ²
Corridor	0.C.18	46.44 m ²
Corridor	0.C.19	49.46 m ²

**Ground Floor D -
Administration**

Name	Number
Grant/Procurement	0.0.01
Meeting room	0.0.02
WC staff	0.0.03
WC room	0.0.04
Rest	0.0.05
Country director/hospital director	0.0.06
D.U.R.	0.0.07
Archive	0.0.08
Head nurse/ Medical coordinator	0.0.09
General director	0.0.10
Admin.	0.0.11
HR	0.0.12
Corridor	0.0.13

Ground Floor E - Diagnosis

Name	Number	Area
X-Ray	0.E.01	19.54 m ²
CH	0.E.02	3.34 m ²
CH	0.E.03	3.31 m ²
X-Ray	0.E.04	29.57 m ²
WC staff	0.E.05	3.73 m ²
WC staff	0.E.06	3.75 m ²
Rest	0.E.07	10.52 m ²
D.U.R.	0.E.08	5.43 m ²
C.U.R.	0.E.09	4.32 m ²
Control room	0.E.10	10.21 m ²
Store	0.E.11	3.40 m ²
CH	0.E.12	3.40 m ²
CT scan	0.E.13	36.52 m ²
WC public	0.E.14	3.58 m ²
WC public	0.E.15	3.58 m ²
Waiting room	0.E.16	26.42 m ²
Locale	0.E.17	52.23 m ²

Ground Floor F - ICU

Name	Number of people
CH (male)	0.51
CH (female)	0.52
Medication room	0.53
Nursing station	0.54
Rest	0.55
WC staff	0.56
WC staff	0.57
WC	0.58
WC	0.59
ICU	0.510
Filter	0.511
Iso	0.512
WC	0.513
D.U.R.	0.514
General supply store	0.515
Instrument store	0.516
C.U.R.	0.517
Linens store	0.518
Corridor	0.519

**Ground Floor G -
Maternity**

Name	Number
Delivery rooms	0.0.01
WC	0.0.02
WC	0.0.03
Delivery room	0.0.04
Delivery room	0.0.05
WC	0.0.06
Medical store	0.0.07
D.U.R.	0.0.08
Post partum	0.0.09
WC	0.0.10
Post partum	0.0.11
WC	0.0.12
Post partum	0.0.13
WC	0.0.14
Post partum	0.0.15
Locale	0.0.16
Post partum	0.0.17
Locale	0.0.18
HDU	0.0.19
WC	0.0.20
GPO obstetric	0.0.21
GPO neonatal	0.0.22
WC public	0.0.23
WC	0.0.24

**Ground Floor G -
Maternity**

Name	Number	Area
OPD obstat	0.25	14.44 m ²
OPD obstat	0.26	14.49 m ²
Reception	0.27	7.41 m ²
Waiting	0.28	5.42 m ²
Admission room	0.29	48.47 m ²
Rest	0.30	7.50 m ²
Doctors' room	0.31	7.65 m ²
Corridor	0.32	8.72 m ²
WC staff	0.33	3.48 m ²
WC staff	0.34	3.54 m ²
C.U.R.	0.35	16.57 m ²
Neonatal island	0.36	16.09 m ²
Nursing station	0.37	16.12 m ²
Delivery room	0.38	16.09 m ²
WC	0.39	3.35 m ²
Delivery room	0.40	3.95 m ²
Delivery room	0.41	16.83 m ²
Corridor	0.42	46.97 m ²
Corridor	0.43	87.09 m ²
Corridor	0.44	4.00 m ²
Corridor	0.45	17.86 m ²
Corridor	0.46	26.62 m ²
Waiting room	0.47	41.95 m ²
Corridor	0.48	4.28 m ²

Ground Floor H - OT

Name	Number of people
CH (male)	0.01
WC staff	0.02
WC staff	0.03
CH (female)	0.04
Recovery	0.05
Store	0.06
OT 2	0.07
Neonatal resuscitation	0.08
Pain Washing	0.09
OT 1	0.10
Anaesthetics store	0.11
Doctors' room	0.12
Rest	0.13
Instruments store	0.14
D.U.R.	0.15
Consumables store	0.16
Technical room	0.17
C.U.R.	0.18
OT 4	0.19
Pain Washing	0.21
OT 3	0.22
Filter	0.23
Corridor	0.24
Corridor	0.25

Ground Floor I - Trauma
HDU

Name	Number	Area
CH	0.101	
Switch board	0.102	
C.U.R.	0.103	
Medical store	0.104	
D.U.R.	0.105	
Nursing Station	0.106	
Rest	0.107	
Doctors' room	0.108	
Corridor	0.109	
WC staff	0.110	
WC staff	0.111	
Isolation	0.112	
WC	0.113	
Filter	0.114	
WC	0.115	
Meeting room	0.116	
Corridor	0.117	
Corridor	0.118	

Ground Floor and Services

Name	N
Main entrance	
Comidor	
Store	
Technical	
Switch board	
Technical Room	
Comidor	
Comidor	

Room schedules

- the Doctors' rooms include resting and meeting area
- the C.U.R. rooms (Clean Utility Room) include 4 sqm. of linen storage space
- the D.U.R. rooms (Dirty Utility Room) include 1 sluice
- the Nursing stations room include 1 sink, storage space, 1 dressing trolley, 1 emergency cart



First floor A - Trauma Wards		
Name	Number Area	
Ward	1.6.1	51.21 m ²
WC	1.6.2	4.39 m ²
Ward	1.6.3	52.63 m ²
Ward	1.6.4	4.39 m ²
Ward	1.6.5	52.39 m ²
Ward	1.6.6	4.45 m ²
CH	1.6.7	7.19 m ²
Isolation	1.6.8	24.32 m ²
Ward	1.6.9	4.60 m ²
Public	1.6.10	4.07 m ²
WC public	1.6.11	4.74 m ²
Medical store	1.6.12	13.77 m ²
C.U.R	1.6.13	14.06 m ²
Ward	1.6.14	52.56 m ²
WC	1.6.15	4.39 m ²
D.U.R	1.6.16	9.48 m ²
WC staff	1.6.17	3.73 m ²
Ward	1.6.18	4.38 m ²
Nursing station	1.19	19.02 m ²
Ward	1.20	47.56 m ²
WC	1.21	4.39 m ²
Ward	1.22	51.02 m ²
WC	1.23	4.22 m ²

First floor A - Trauma Wards		
Name		Number Area
WC	1.24	3.24 m ²
WC	1.25	3.24 m ²
Rest	1.26	41.67 m ²
Medical coordination	1.27	12.06 m ²
Nurse Name	1.28	12.71 m ²
Doctors' room	1.29	12.06 m ²
WC public	1.30	0.08 m ²
WC public	1.31	6.17 m ²
Medical store	1.32	4.41 m ²
Ward	1.33	50.08 m ²
Ward	1.34	4.39 m ²
Ward	1.35	52.91 m ²
Ward	1.36	4.44 m ²
Ward	1.37	51.51 m ²
WC	1.38	4.24 m ²
Ward	1.39	51.95 m ²
Ward	1.40	4.44 m ²
Ward	1.41	52.45 m ²
Ward	1.42	4.44 m ²
Nursing station	1.43	19.04 m ²
WC staff	1.44	4.37 m ²
WC staff	1.45	3.88 m ²
D.U.R	1.46	9.19 m ²

Name	Number	Area
Ward	1.A.47	52.22 m ²
WC	1.A.48	4.37 m ²
C.U.R.	1.A.49	13.97 m ²
Corridor	1.A.50	153.34 m ²
Corridor	1.A.51	102.44 m ²

Name	Area
WC	1.5.41 36.92 m ²
WC	1.5.62 4.63 m ²
Ward	1.5.63 31.07 m ²
WC	1.5.04 4.23 m ²
Ward	1.5.66 4.21 m ²
Ward	1.5.66 31.08 m ²
Ward	1.5.67 34.75 m ²
WC	1.5.06 4.65 m ²
Nursing station	1.5.69 13.52 m ²
WC staff	1.5.10 3.35 m ²
WC staff	1.5.11 3.34 m ²
D.I.R.	1.5.12 7.25 m ²
Doctors' room	1.5.13 12.53 m ²
Rest	1.5.14 9.12 m ²
Medical store	1.5.15 9.11 m ²
C.I.R.	1.5.16 9.11 m ²
Corridor	1.5.17 50.89 m ²

Name	Number	Area
Office	1.2.01	13.89 m ²
Microbiology	1.2.02	52.46 m ²
Parasitology	1.2.03	14.41 m ²
Reception	1.2.04	37.81 m ²
Core Lab	1.2.05	107.18 m ²
PGR	1.2.06	7.21 m ²
Store	1.2.07	18.60 m ²
WC staff	1.2.08	3.12 m ²
WC stud	1.2.09	5.11 m ²
Blood bank Room	1.2.10	47.26 m ²
Corridor	1.2.11	15.04 m ²

Name	Number	Area
Stone	1.0.01	2.51 m ²
CH (male)	1.0.02	9.96 m ²
CH (female)	1.0.03	14.07 m ²
Stone	1.0.04	2.93 m ²
Gym	1.0.05	86.47 m ²
Corridor	1.0.06	20.69 m ²
Corridor	1.0.07	7.67 m ²

First floor E - Maternity	
Name	Number Area
Island	1.E.01 62.83 m ²
Ward	1.E.02 4.39 m ²
Ward	1.E.03 80.22 m ²
Ward	1.E.04 4.39 m ²
Nursing station	1.E.05 18.70 m ²
WC staff	1.E.06 4.50 m ²
WC staff	1.E.07 3.89 m ²
D.U.R.	1.E.08 9.30 m ²
Ward	1.E.09 5.45 m ²
Ward	1.E.10 4.40 m ²
Ward	1.E.11 32.70 m ²
WC	1.E.12 4.62 m ²
NCIU	1.E.13 30.88 m ²
Switch station	1.E.14 2.21 m ²
Fiber	1.E.15 3.20 m ²
Fiber	1.E.16 1.15 m ²
Isolation	1.E.17 7.05 m ²
HDU	1.E.18 2.32 m ²
WC	1.E.19 5.34 m ²
Nursing station	1.E.20 11.65 m ²
Doctors' room	1.E.21 10.21 m ²
WC staff	1.E.22 3.16 m ²
WC staff	1.E.23 3.21 m ²

First floor E - Maternity		
Name	Number	Area
Reception	1.6-6	6.54 m ²
Outborn HDU	1.25	79.24 m ²
Nursing	1.26	4.51 m ²
Waiting station	1.27	6.25 m ²
Reception NCU	1.28	23.11 m ²
Filter	1.29	3.52 m ²
Room NCU	1.30	8.43 m ²
D.U.R.	1.31	8.50 m ²
WC staff	1.32	4.18 m ²
WC	1.33	4.15 m ²
Rest	1.34	17.02 m ²
D.U.R.	1.35	8.50 m ²
C.U.R.	1.36	16.14 m ²
Reception store	1.37	17.90 m ²
WC	1.38	10.99 m ²
Clinic	1.39	11.81 m ²
WC	1.40	4.69 m ²
WC	1.41	64.98 m ²
WC public	1.42	4.04 m ²
WC public	1.43	1.62 m ²
SB	1.44	3.45 m ²
WC	1.45	92.58 m ²
WC	1.46	3.37 m ²

Name	Number Area	
Doctors' room	1.5.47	9.88 m ²
Rest	1.5.48	8.12 m ²
Ward	1.5.49	52.32 m ²
WC	1.5.50	4.39 m ²
Ward	1.5.51	52.99 m ²
WC	1.5.52	4.39 m ²
Corridor	1.5.53	117.11 m ²
Corridor	1.5.54	40.72 m ²
Corridor	1.5.55	33.14 m ²
Flare	1.5.56	8.30 m ²
Corridor	1.5.57	34.31 m ²
Canteen/Rest	1.5.58	45.74 m ²
WC	1.5.59	4.94 m ²
WC	1.5.60	4.93 m ²
Mother annex	1.5.61	109.02 m ²

Name	Number	Area
C.I.C.	1.5	7.24 m ²
WC	1.5	0.82 x 0.94 m ²
Isolation	1.5	0.23 x 0.78 m ²
Filter	1.5	0.04 x 0.78 m ²
Ward	1.5	0.65 x 0.43 m ²
Ward	1.5	0.66 x 0.42 m ²
Doctors' room	1.5	0.27 x 0.95 m ²
Rest	1.5	0.06 x 0.05 m ²
WC	1.5	0.89 x 0.33 m ²
Ward	1.5	1.0 x 0.49 m ²
Ward	1.5	1.11 x 0.14 m ²
Ward	1.5	0.12 x 0.39 m ²
Nursing station	1.5	0.13 x 0.23 m ²
WC staff	1.5	0.14 x 0.12 m ²
WC staff	1.5	0.14 x 0.17 m ²
D.U.R.	1.5	0.16 x 0.15 m ²
Ward	1.5	0.17 x 0.51 m ²
Ward	1.5	0.16 x 0.32 m ²
Corridor	1.5	0.17 x 0.33 m ²

Name	Number	Area
Corridor	1.0.01	688.52 m ²
Technical	1.0.02	5.46 m ²
Meeting room	1.0.03	24.25 m ²

F

F

C

R

[illegible]

Municipality
AL RASTAN
(SY)

Client: **EMERGENCY ONG ETS**
via S. Croce, 19
Milan (Italy)

Site address:

M5 road
Al Rastan (Syria)

ARH
AL RASTAN HOSPITAL
Renovation

Architectural project

 **TAMassociati**

TAMassociati
Dorsoduro 2731 | 30123 Venice (Italy)
+39 3483141267 | info@tamassociati.org

 **EMERGENCY** building division
via S. Croce, 19 | 20122 Milan (Italy)
+39 02881881 | info@emergency.it

Design Team

Local medical planner:

 **Innotech Medical**

Innotech Medical
Eng Bahas Al Sairafi
Office #303, Al Rayhan | Building Al Manzar, Dubai, UAE
+971 506726988
Teliyani, near the Italian Hospital | Damascus, Syria
+963 959250880 | +963 9116440305 | a.alsairafi@innotech-med.com

MEP engineering:

 Rethink Energy

Rethink Energy
via Francesco Melzi d'Eril, 26 | 20154 Milano (Italy)
+39 0245558885 | info@studio-re.eu

Preliminary project

First Floor - Project

Date:	Scale:
03/07/26	1 : 200

Rev.	Date	DRW	CHK	APR	Description

Drawing number:
ARH-A 003

- the Doctors' rooms include resting and meeting area
- the C.U.R. rooms (Clean Utility Room) include 4 sqm. of linen storage space
- the D.U.R. rooms (Dirty Utility Room) include 1 sluice
- the Nursing stations room include 1 sink, storage space, 1 dressing trolley, 1 emergency cart



Name	Number	Area
WC public	2.A.01	3.82 m ²
WC public	2.A.02	3.79 m ²
Meeting room	2.A.03	18.86 m ²
Teaching room	2.A.04	35.48 m ²
Teaching room	2.A.05	35.26 m ²
WC public	2.A.06	3.83 m ²
WC public	2.A.07	3.87 m ²
Store	2.A.08	13.20 m ²
WC	2.A.09	3.53 m ²
On call	2.A.10	11.93 m ²
On call	2.A.11	10.14 m ²
WC	2.A.12	2.92 m ²
WC	2.A.13	2.92 m ²
On call	2.A.14	10.14 m ²
On call	2.A.15	11.93 m ²
WC	2.A.16	3.53 m ²
Cafeteria	2.A.17	13.20 m ²
Corridor	2.A.18	163.20 m ²

Key plan

1. This drawing is a copyright © of TAMassociati
2. Do not scale off this drawing
3. All levels and dimensions to be checked on site before any building work commences
4. Any discrepancies to be reported to the office of the consultant
5. All work to be strictly in accordance with the standard specifications and notes
6. This drawing is to be read in conjunction with specifications and all other relevant drawings
7. All dimensions are in meters unless differently specified in the drawings

Client: **EMERGENCY ONG ETS**
via S. Croce, 19
Milan (Italy)

Site address: M5 road
Al Rastan (Syria)

AL RASTAN HOSPITAL

Renovation

Architectural project

 **TAMassociati**

TAMassociati

Dorsoduro 2731 | 30123 Venice (Italy)
+39 3483141267 | info@tamassociati.org

 EMERGENCY building division
via S. Croce, 19 | 20122 Milan (Italy)
+39 02881881 | info@emergency.it

Design Team

Local medical planner:

 Innotech Medical

Innotech Medical
Eng. Bahaa Al Sairafi
Office #303, Al Rayhan | Building Al Mamzar, Dubai, UAE
+971 506726988
Telriany, near the Italian Hospital | Damascus, Syria
+963 950250880 | +963 116440305 | b.alsairafi@innotech-med.com

MEP engineering:

 **Rethink Energy**

Rethink Energy
via Francesco Melzi d'Eril, 26 | 20154 Milano (Italy)
+39.02.4556995 | info@rethink.energy

Preliminary project

Second Floor - Project

[illegible]

Drawing number:

ARH-A.004



Key plan

Notes:

1. This drawing is a copyright © of TAMassociati
2. Do not scale off this drawing
3. All levels and dimensions to be checked on site before any building work commences
4. Any discrepancies to be reported to the office of the consultant
5. All work to be strictly in accordance with the standard specifications and notes
6. This drawing is to be read in conjunction with specifications and all other relevant drawings
7. All dimensions are in meters unless differently specified in the drawings

Municipality
AL RASTAN
(SY)

Client:

EMERGENCY ONG ETS
via S. Croce, 19
Milan (Italy)

Site address:

M5 road
Al Rastan (Syria)

ARH

AL RASTAN HOSPITAL
Renovation

Architectural project



TAMassociati
Dorsoduro 2731 | 30123 Venice (Italy)
+39 3453141287 | info@tamassociati.org



EMERGENCY building division
via S. Croce, 19 | 20122 Milan (Italy)
+39 02981181 | info@emergency.it

Design Team

Local medical planner:



Innotech Medical
Eng. Bahaa Al Satri
Office #303, Al Rayhan | Building Al Munzer, Dubai, UAE
+971 50875995
Toll-free: near the Italian Hospital | Damascus, Syria
+963 95925080 | +963 116440355 | b.alsatri@innotech-med.com

MEP engineering:




Rethink Energy
via Francesco Melzi d'Eril, 26 | 20154 Milano (Italy)
+39 0245556655 | info@studio-re.eu

Preliminary project
Elevations

Date:		Scale:			
05/06/26		1 : 200			
Rev.	Date	DRW	CHK	APR	Description


Drawing number:

ARH-A.009

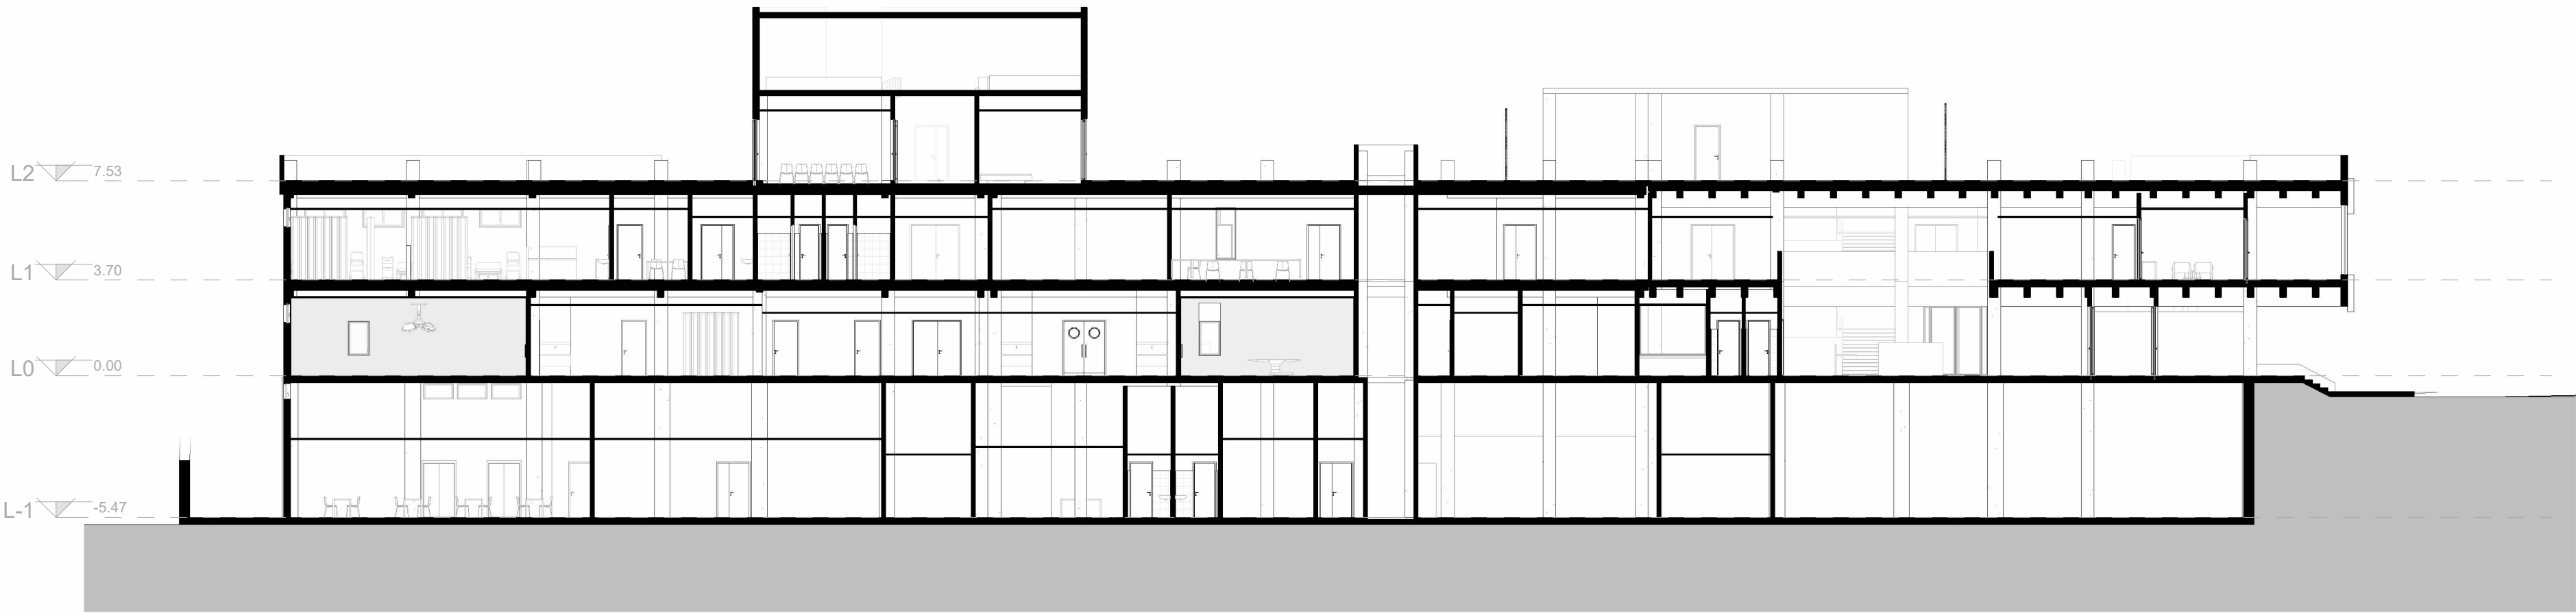


Section A-A'

1 : 200

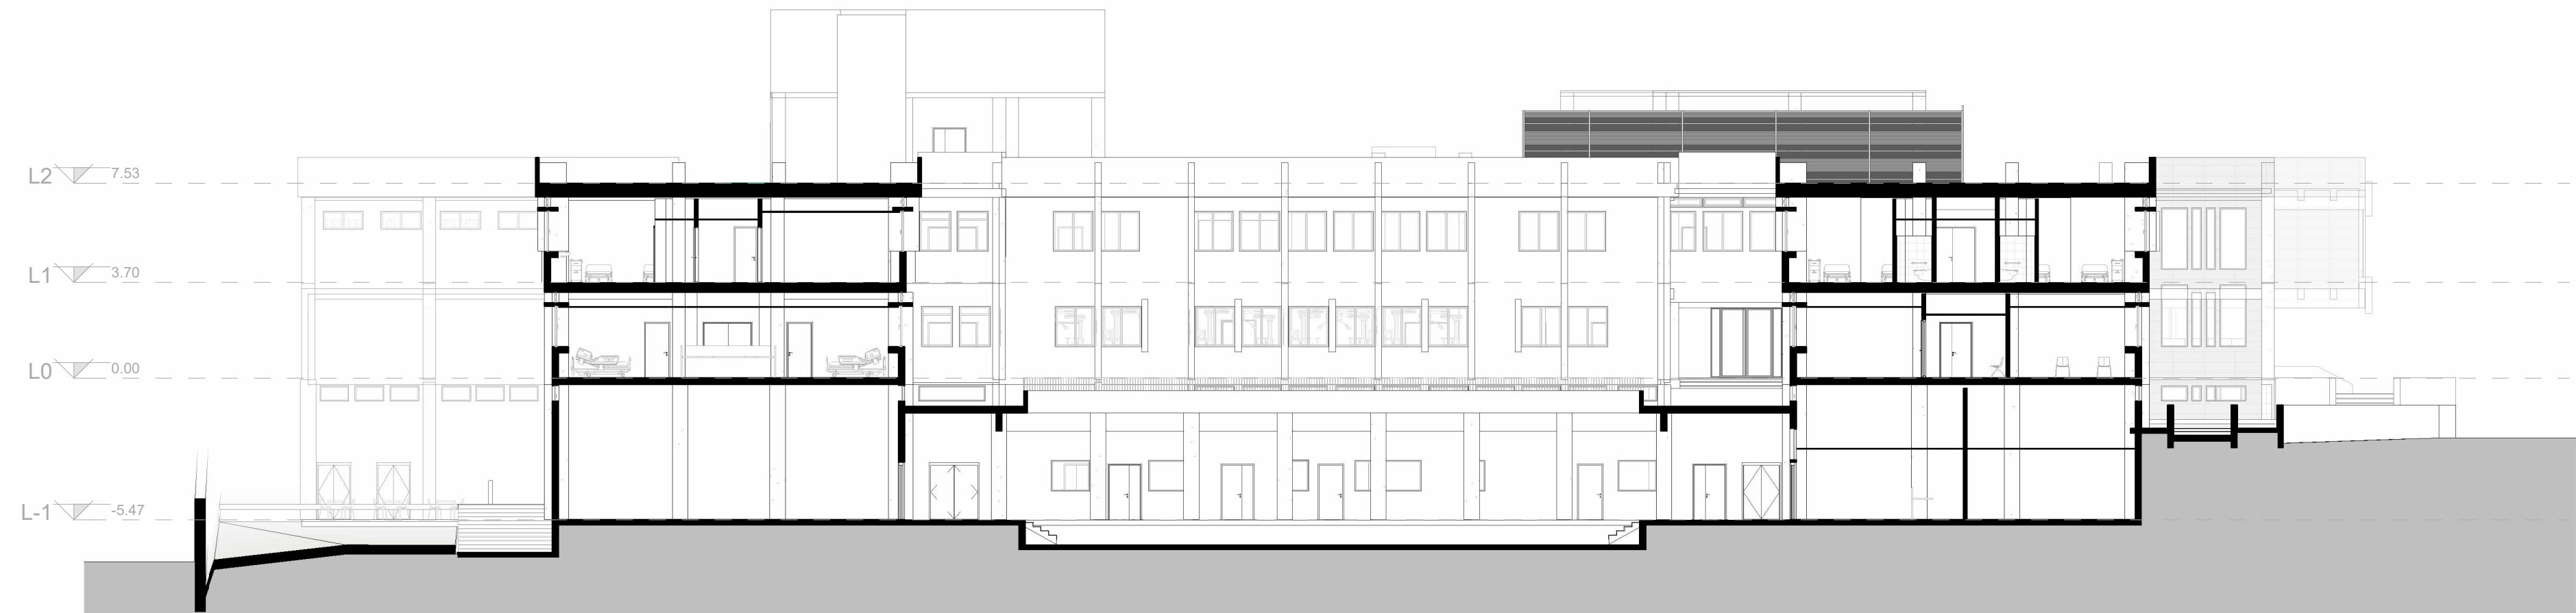

Section B-B'

1 : 200

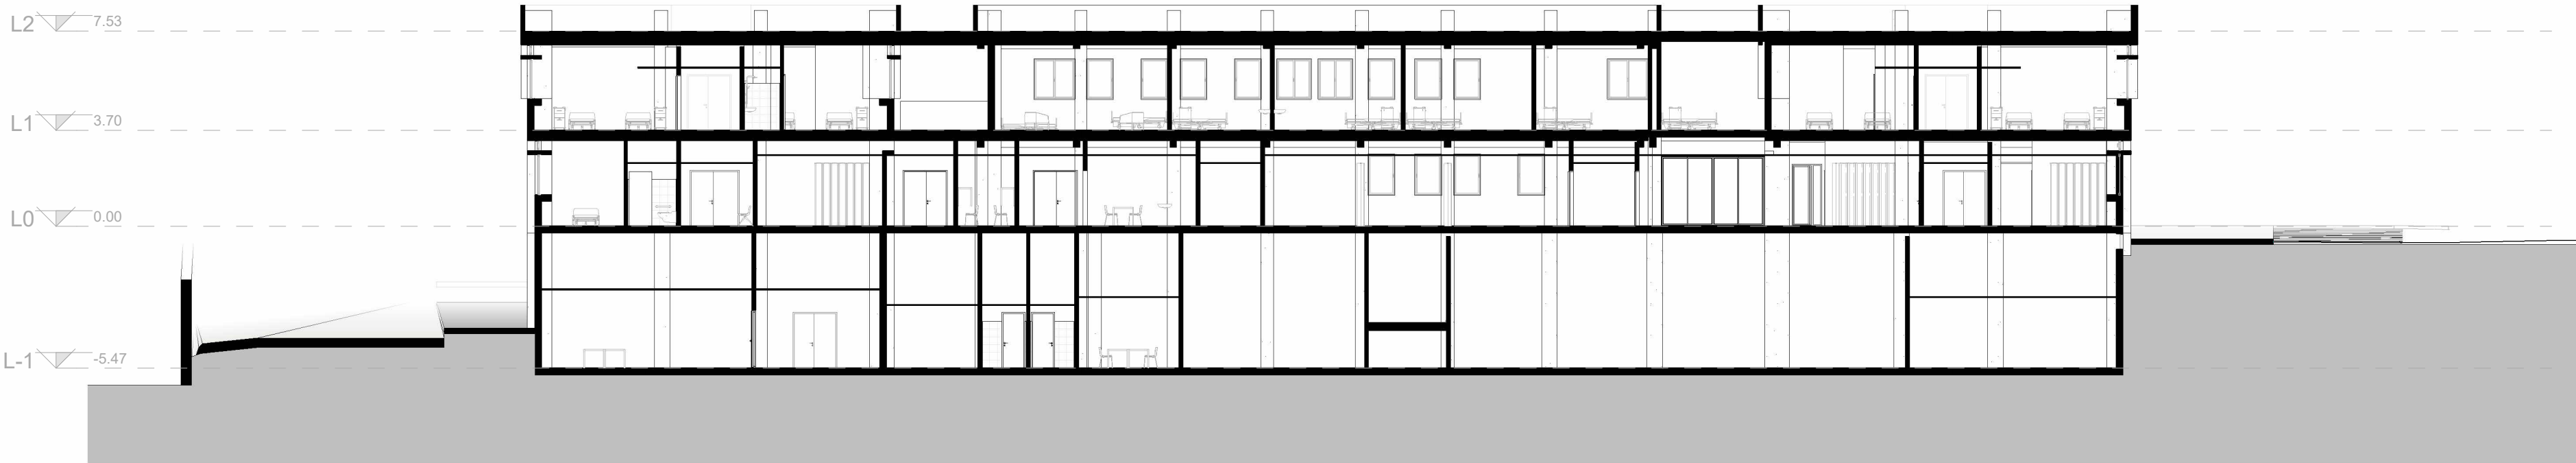

Section C-C'

1 : 200

Key plan

Notes:

1. This drawing is a copyright © of TAMassociati
2. Do not scale off this drawing
3. All levels and dimensions to be checked on site before any building work commences
4. Any discrepancies to be reported to the office of the consultant
5. All work to be strictly in accordance with the standard specifications and notes
6. This drawing is to be read in conjunction with specifications and all other relevant drawings
7. All dimensions are in meters unless differently specified in the drawings

Municipality
**AL RASTAN
(SY)**

Client:

EMERGENCY ONG ETS

via S. Croce, 19
Milan (Italy)

Site address:

M5 road
Al Rastan (Syria)

ARH

**AL RASTAN HOSPITAL
Renovation**

Architectural project

TAMassociati

TAMassociati
Dorsoduro 2731 | 30123 Venice (Italy)
+39 3453141287 | info@tamassociati.org

EMERGENCY

EMERGENCY building division
via S. Croce, 19 | 20122 Milan (Italy)
+39 02981181 | info@emergency.it

Design Team

Local medical planner:

Innotech Medical

Innotech Medical
Eng Bahaa Al Satri
Office #303, Al Rayhan | Building Al Munzer, Dubai, UAE
+971 50875995
Tallary, near the Italian Hospital | Damascus, Syria
+963 95925980 | +963 116440355 | b.alsatri@innotech-med.com

MEP engineering:

Rethink Energy

Rethink Energy
via Francesco Melzi d'Eril, 26 | 20154 Milano (Italy)
+39 0245558655 | info@studio-re.eu

**Preliminary project
Sections**

Date:		Scale:			
03/07/26		1 : 200			
Rev.	Date	DRW	CHK	APR	Description

Drawing number:

ARH-A.010

Drawing number:

ARH-A.011